



NOT RELEASED FOR CONSTRUCTION COPYRIGHT

This drawing and all reproductions are copyrighted and the property of Make3 architecture/planning/design and may not be used in any way without their permission. © 2017


Vendor will need to provide calculations with their submittal to verify lighting levels are appropriate with the proposed fixtures

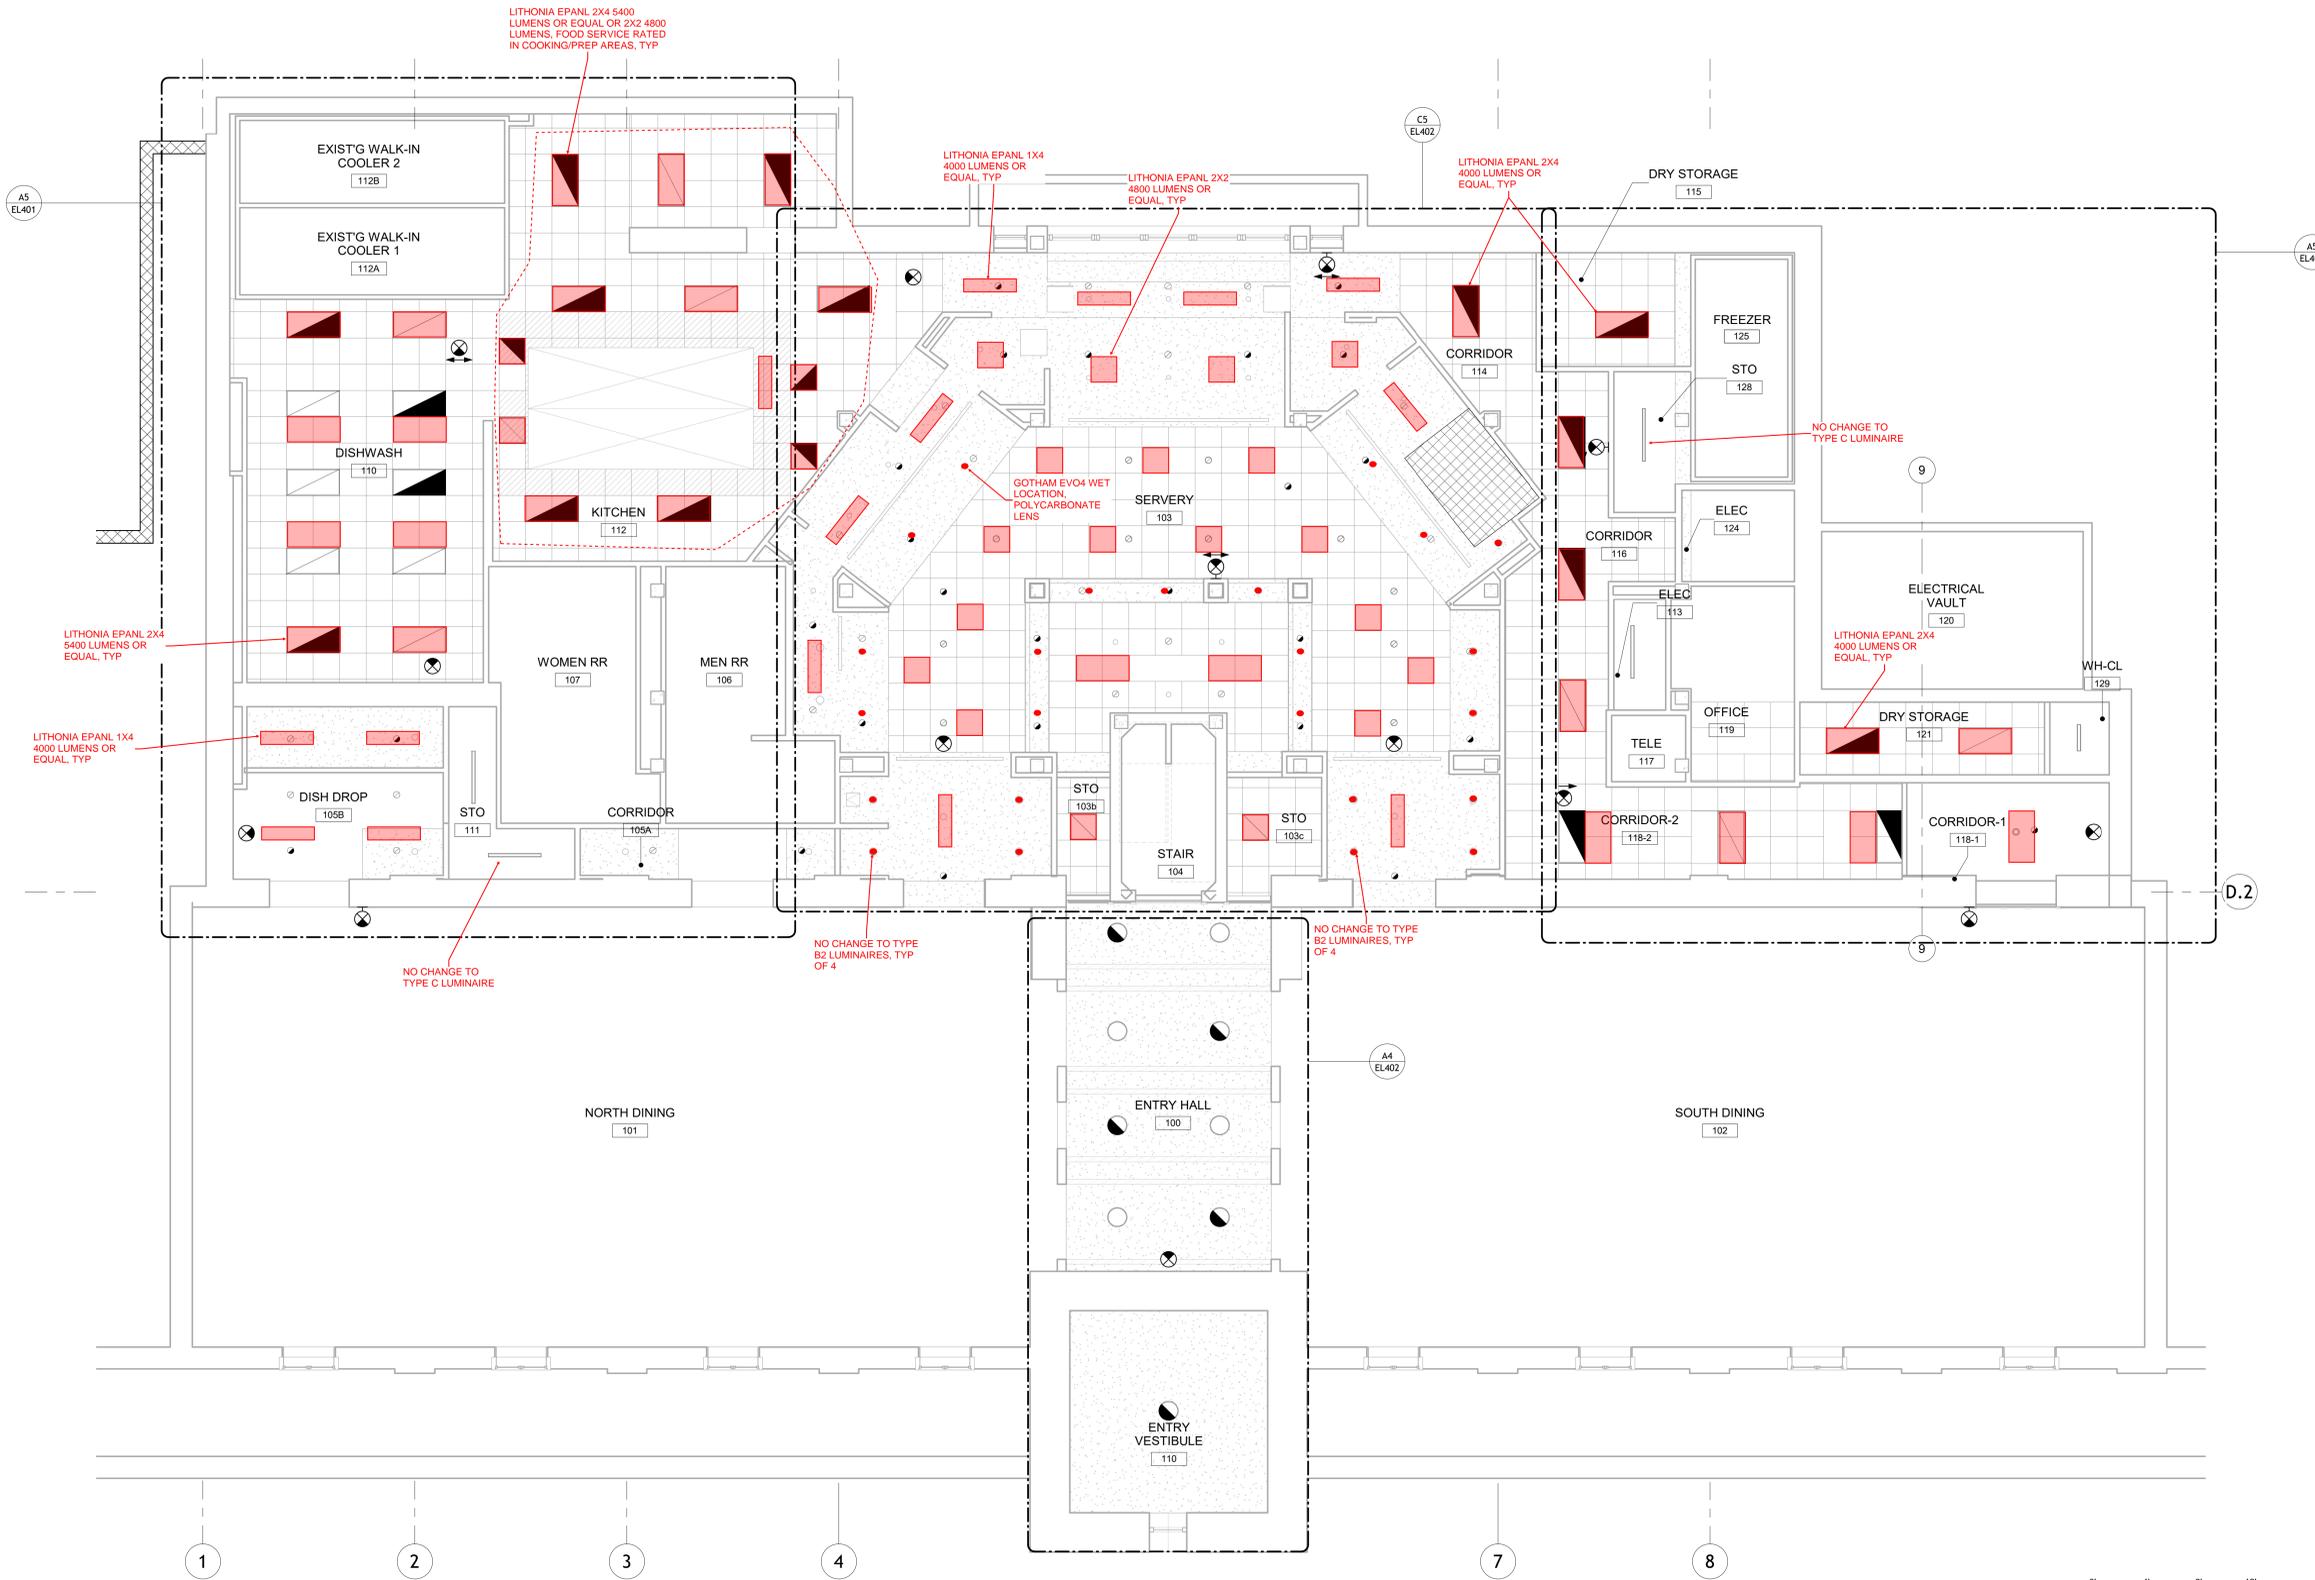

 A7 EL101 FIRST FLOOR - OVERALL LIGHTING PLAN
3/16" = 1'-0"



KEYPLAN

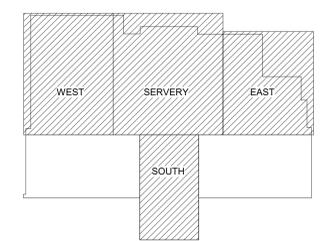

BRITAIN DINING HALL RENOVATION

GEORGIA INSTITUTE OF TECHNOLOGY

649 TECHWOOD DRIVE NW
ATLANTA, GA 30330

DRAWN BY	CHECKED BY
RDY	RCC
DATE	
10/17/2025	

REVISION	TITLE

FIRST FLOOR
OVERALL
LIGHTING
PLAN

PROJECT NUMBER
202406

SHEET NUMBER
EL101